


6 QUAD & O.F.C. CABLE ROUTE PLAN OF
SITAPUR JN. - MAILANI JN. SECTION
NORTH EASTERN RAILWAY
(LUCKNOW DIVISION)

SUBMITTED BY:

M/S. ASHOK KUMAR SINGH
JAGARNATH PUR, GORAKHPUR

6 QUAD & O.F.C. CABLE ROUTE PLAN (SITAPUR JN. - MAILANI JN.)

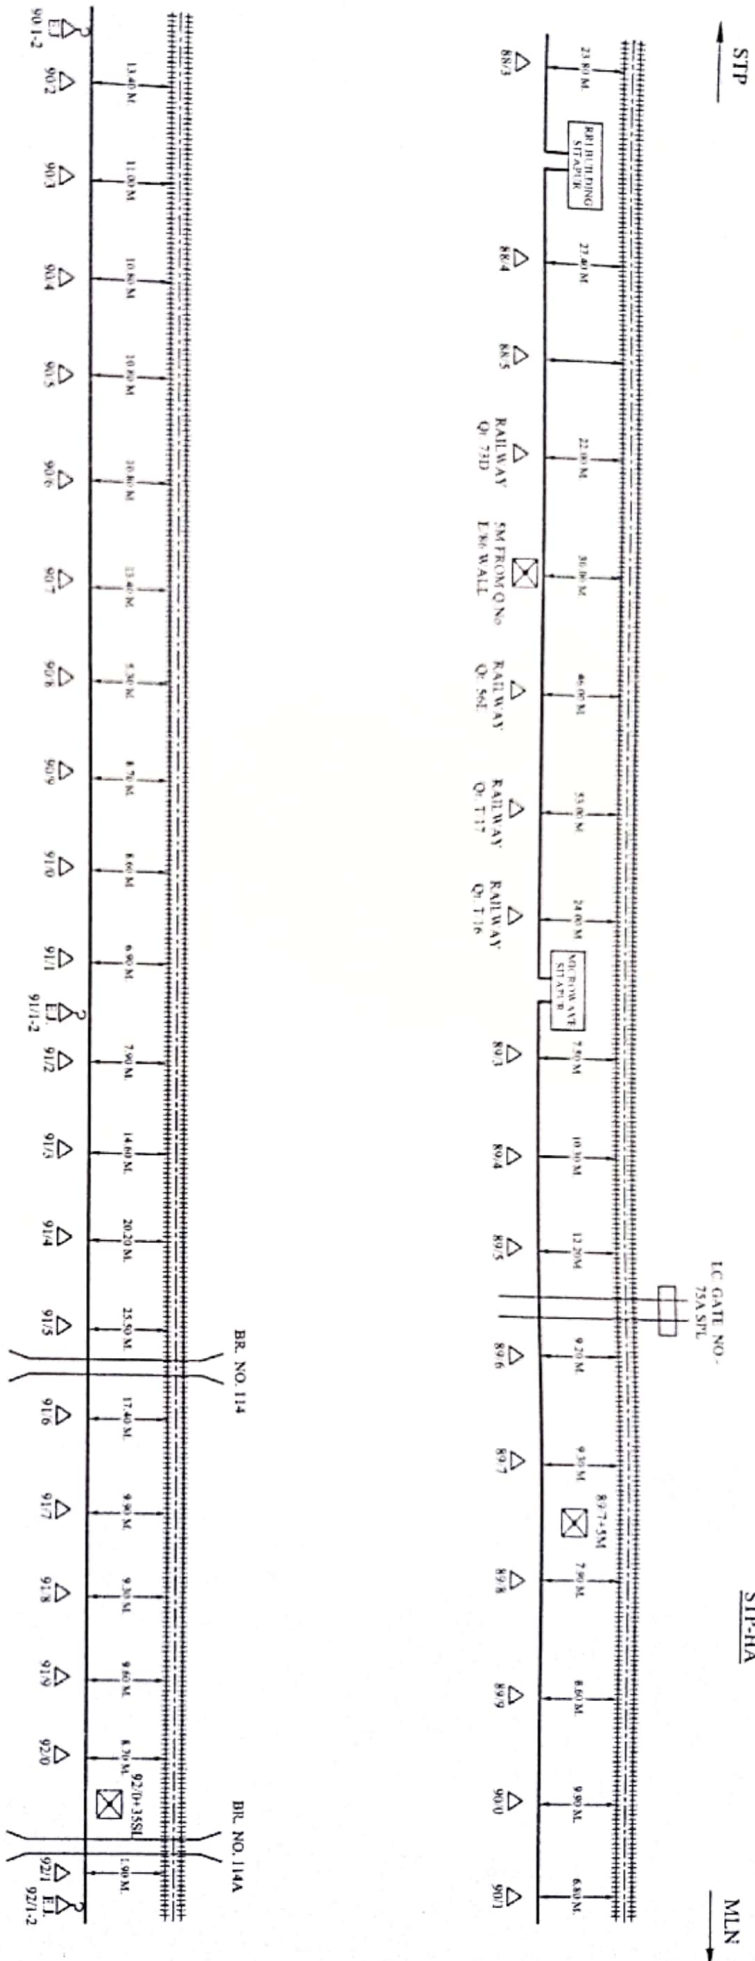

CONTRACTOR

SSE TELE CON/LIN

DSE/CON/LIN

DY/CSE/CON/LIN


EMERGENCY SOCKET	GATE LODGE	RUB	L.C. PHONE
LEVEL CROSSING GATE	MAJOR BRIDGE	GL PIPE	CABLE THROUGH PIPE
OFC JOINT	TRACK	HDP PIPE	CABLE UNDER GROUND

CUSTOMER NAME	N.E. RAILWAY
PREPARED BY	M.S. ASHOK KUMAR SINGH, JAGANNATH PUR, GORAKHPUR
SHEET NO	01
CREATED ON	OFFERED BY
REVISION ON	APPD. BY
MODIFIED ON	REF. NE/

LOCATION:- SITAPUR JN. - MAILANI JN.

NOT TO SCALE ALL READING IN MTR.

6 QUAD & O.F.C. CABLE ROUTE PLAN (SITAPUR JN - MAILANI JN.)

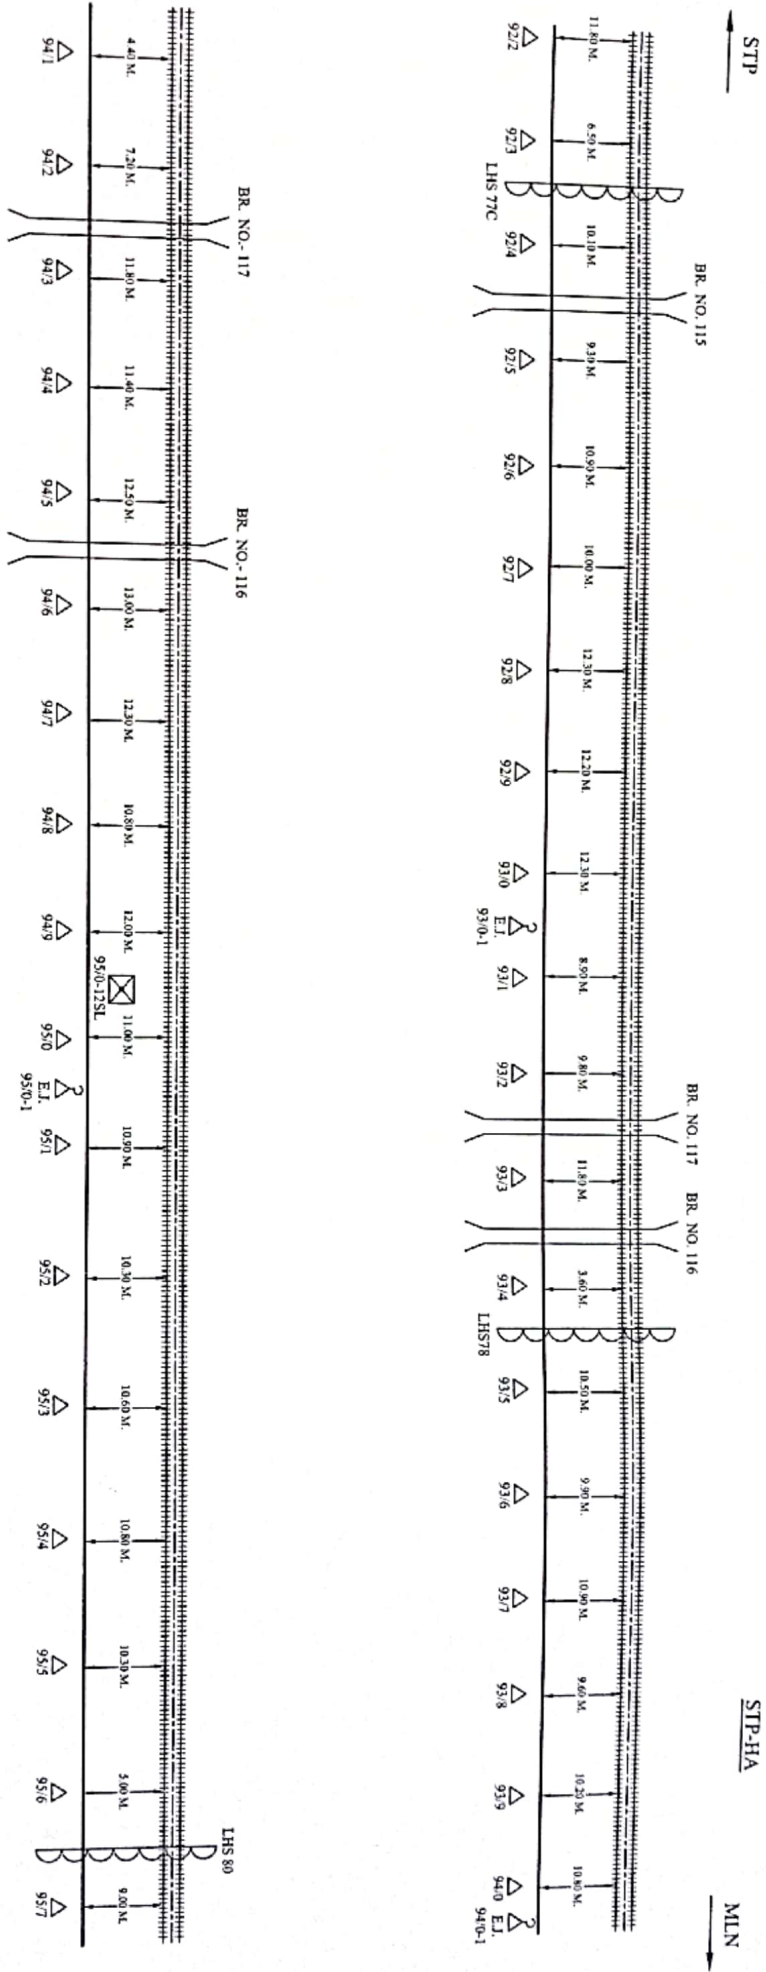

CONTRACTOR
H. Singh

SSE/TELE/CON/LIN
S. Singh

DSTE/CON/LIN
S. Singh

DY/STE/CON/LIN
S. Singh

△	EMERGENCY SOCKET	□	GATE LODGE	⌢	RUB	Σ	L.C. PHONE	SITAPUR JN - MAILANI JN.		
⊞	LEVEL CROSSING GATE	⊞	MAJOR BRIDGE	□	GL PIPE	C/TIP	CABLE THROUGH PIPE			
⊞	OFC JOINT	⊞	TRACK	□	HDPE PIPE	C/U/G	CABLE UNDER GROUND			
⊞		⊞		⊞						

CUSTOMER NAME:		N.E. RAILWAY	
PREPARED BY:		M/s. ASHOK KUMAR SINGH, JAGARNAH PUR, GORAKHPUR	
SHEET NO.		02	
CREATED ON		OFFERED BY	
REVISION ON		APPD. BY	
MODIFIED ON		REF: NE/	

LOCATION:-
SITAPUR JN - MAILANI JN.


NOT TO SCALE ALL READING IN MTR.

(SITAPUR JN.-MAILANI JN.)



NOT TO SCALE ALL READING IN MTR

6 QUAD & O.F.C. CABLE ROUTE PLAN (SITAPUR JN.- MAILANI JN.)

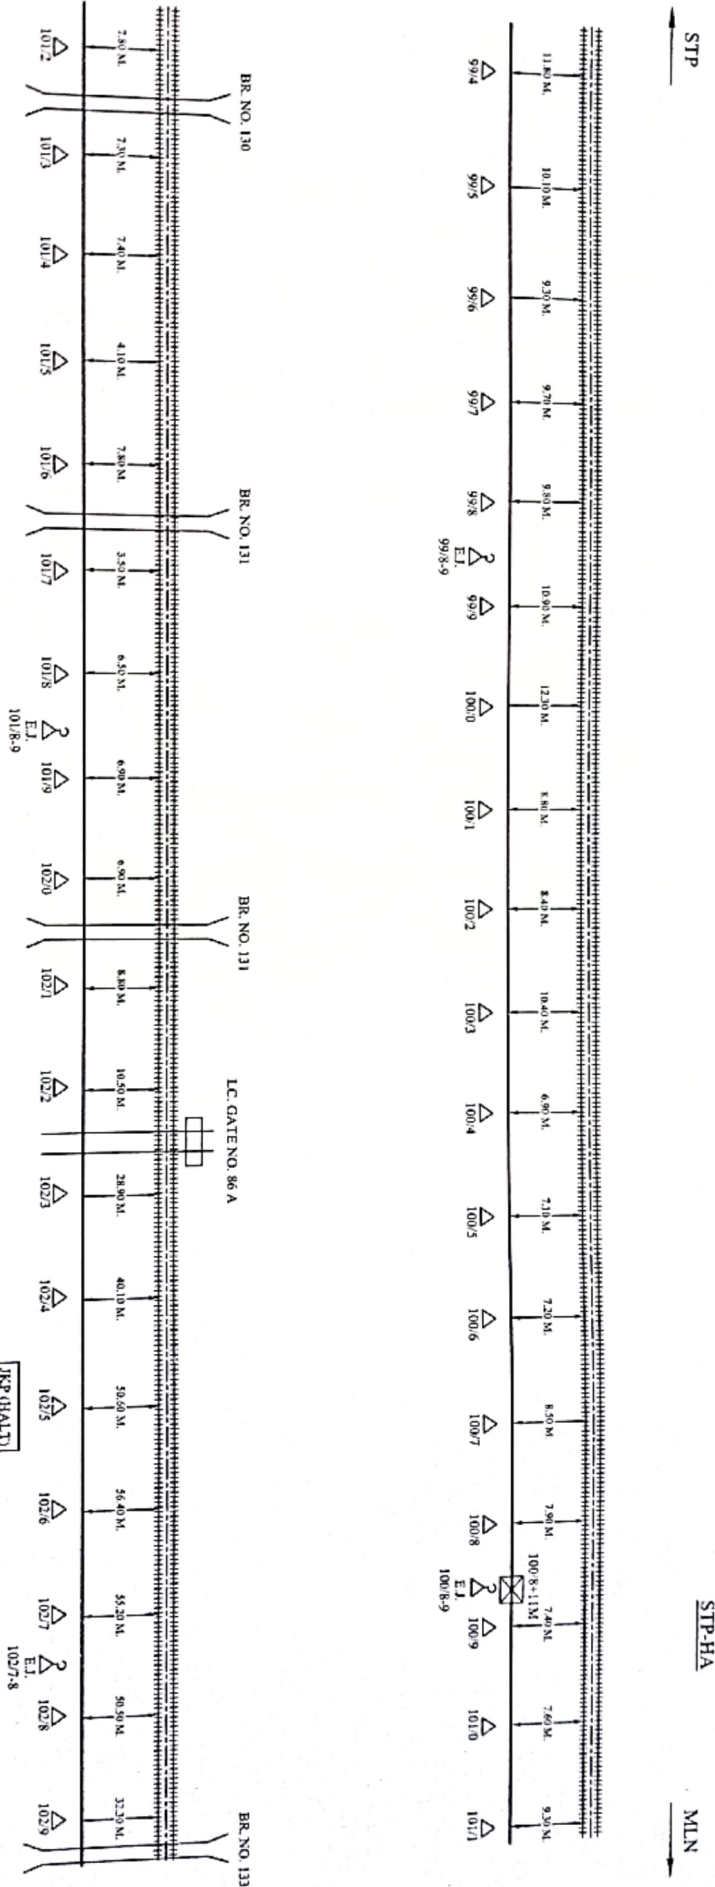

CONTRACTOR

SSE/TELE/CON/LIN

DSTE/CON/LIN

DY/CSTE/CON/LIN

☒	EMERGENCY SOCKET	☐	GATE LODGE	☐	RUB	☐	L.C. PHONE	☐	CREATED BY	☐	OFFERED BY	☐	APPD. BY	☐	REF. NE/	NOT TO SCALE ALL READING IN MTR.
☒	LEVEL CROSSING GATE	☐	MAJOR BRIDGE	☐	G.I. PIPE	☐	C/T/P	☐	CABLE THROUGH PIPE	☐	REVISION ON	☐	MODIFIED ON	☐	REF. NE/	NOT TO SCALE ALL READING IN MTR.
☒	OFC JOINT	☐	TRACK	☐	HIDE PIPE	☐	C/U/G	☐	CABLE UNDER GROUND	☐	MODIFIED ON	☐	REF. NE/	☐	REF. NE/	NOT TO SCALE ALL READING IN MTR.

CUSTOMER NAME: N.E. RAILWAY


PREPARED BY: M.S. ASHOK KUMAR SINGH, JAGANNATH PUR, GORAKHPUR

SHEET NO: 04

LOCATION: SITAPUR JN.- MAILANI JN.

CREATED BY: OFFERED BY: APPD. BY: MODIFIED ON: REF. NE/

6 QUAD & O.F.C. CABLE ROUTE PLAN (SITAPUR JN. - MAILANI JN.)

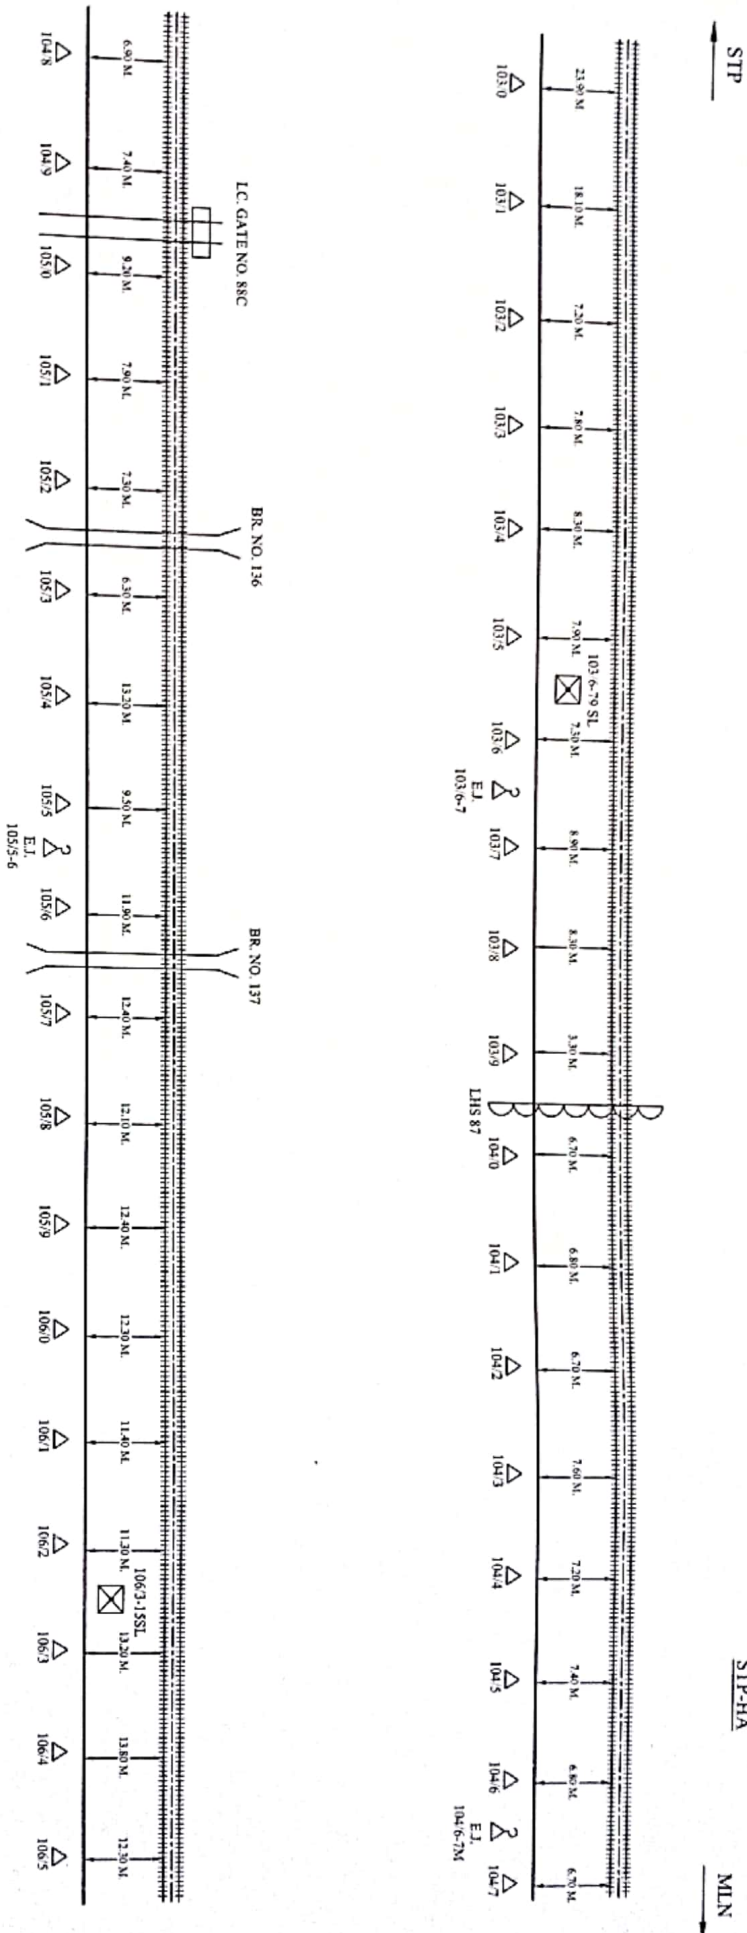

CONTRACTOR		SSE/TELE/CON/LIN		DSTE/CON/LIN		DY/CSTE/CON/LIN	
EMERGENCY SOCKET		GATE LODGE		RUB		L.C. PHONE	
LEVEL CROSSING GATE		MAJOR BRIDGE		G.L PIPE		C/T/P	
OFC JOINT		TRACK		HDPE PIPE		C/U/G	
C/U/G		CABLE UNDER GROUND		MODIFIED ON		REF: NE/	
NOT TO SCALE ALL READING IN MTR.							



CUSTOMER NAME:		N.E. RAILWAY	
PREPARED BY:		M/s. ASHOK KUMAR SINGH, JAGANNATH PUR, GORAKHPUR	
SHEET NO.		05	
CREATED ON		OFFERED BY	
REVISION ON		APPD. BY	
LOCATION:-		SITAPUR JN. - MAILANI JN.	

(SITAPUR JN.-MAILANI JN.)





4 pad
CONTRACTAR

(STAPUR JN.; MAILANI JN.)

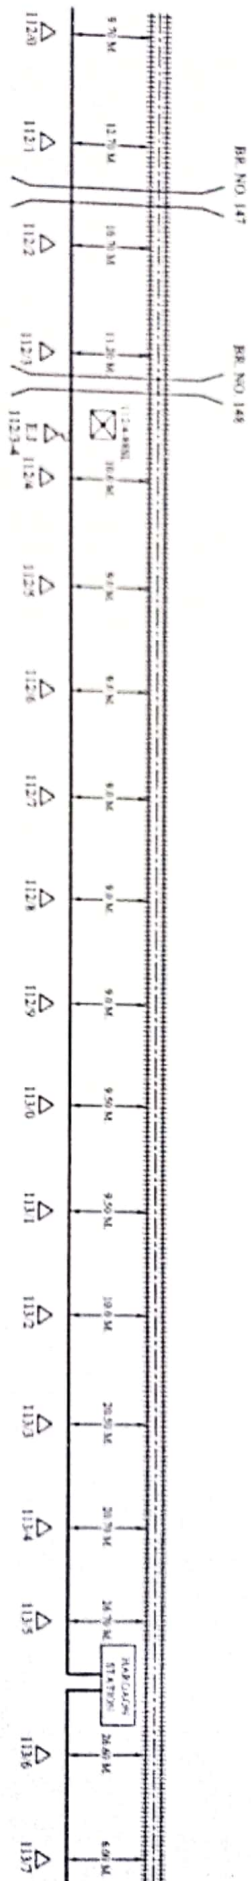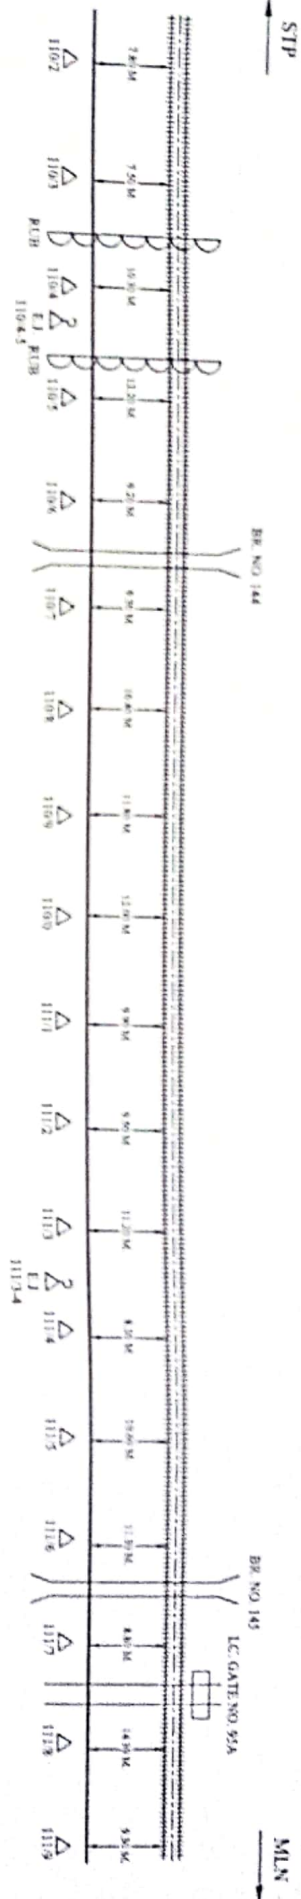

CUSTOMER NAME:		N.E. RAILWAY	
PREPARED BY:		MS. ASHOK KUMAR SINGH, JAGANNATH PUR, GORAKHPUR	
SHEET NO.	07	CREATED BY	
CREATED ON		OFFERED BY	
REVISION ON		APPD. BY	
REVISION ON		APPD. BY	
REF: NE/		LOCATION:-	
MODIFIED ON		SITAPUR JN.- MAILANI JN	
NOT TO SCALE ALL READING IN MTR.			

(SITAPUR HN. MAILANJN)

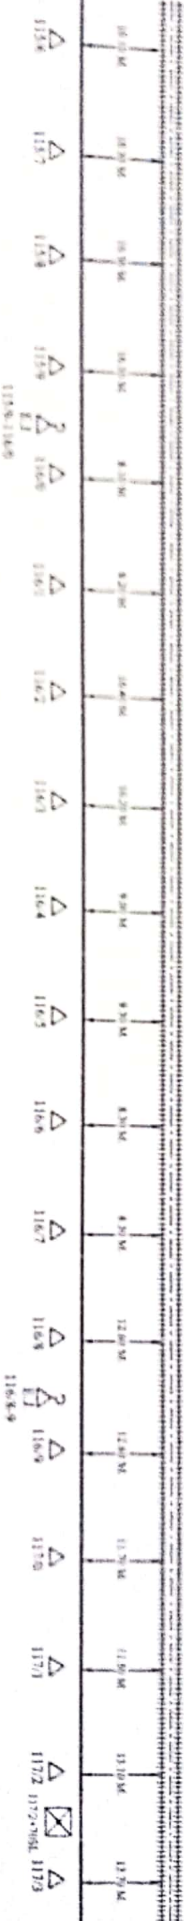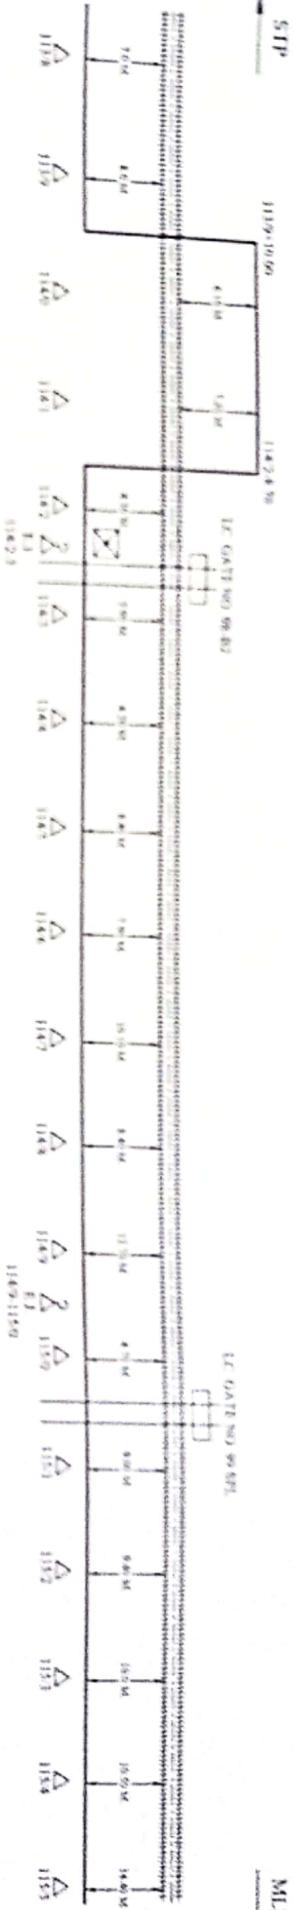

CUSTOMER NAME		N.E. RAILWAY	
PREPARED BY		M.S. ASHOK KUMAR SINGH, JAGADNATH PUR, GORAKHPUR	
SHEET NO	08	CREATED BY	
CREATED ON		OFFERED BY	
REVISION ON		APPROD BY	
MODIFIED ON		REF. NO.	
LOCATION:- SITAPUR JN.- MALLANI JN.			

(SITAPUR JN.-MAILANI JN.)



	EMERGENCY SOCKET		GATE LODGE		RUB		L.C. PHONE
	LEVEL CROSSING GATE		MAJOR BRIDGE		G.I. PIPE		CABLE THROUGH PIPE
	OFC JOINT		TRACK		HDPE PIPE		CABLE UNDER GROUND



CUSTOMER NAME:	N.E. RAILWAY
PREPARED BY:	MS. ASHOK KUMAR SINGH, JAGADNATHPUR, GORAKHPUR

SITAPUR JN.-MAILANI JN

6 QUAD & O.F.C. CABLE ROUTE PLAN (SITAPUR JN - MAILANI JN)

HA-1-MP

MLN

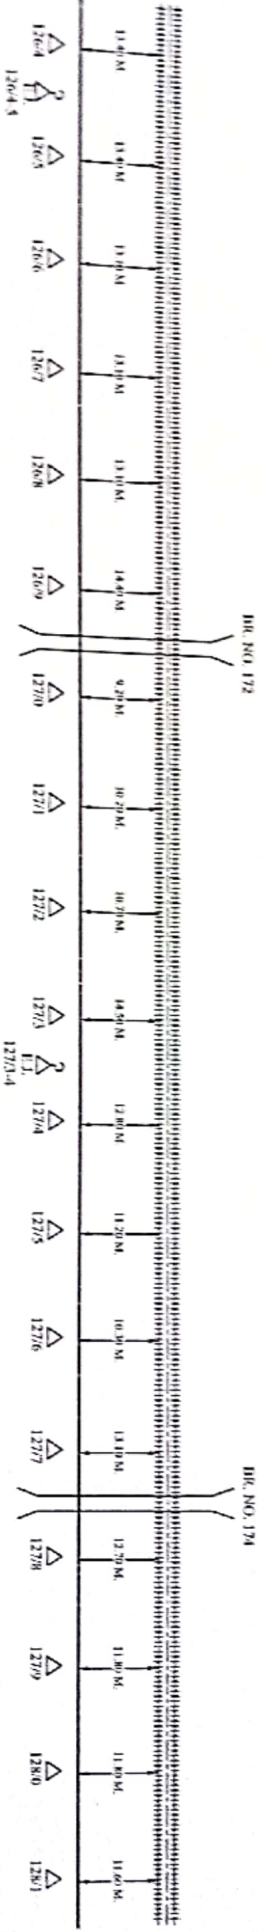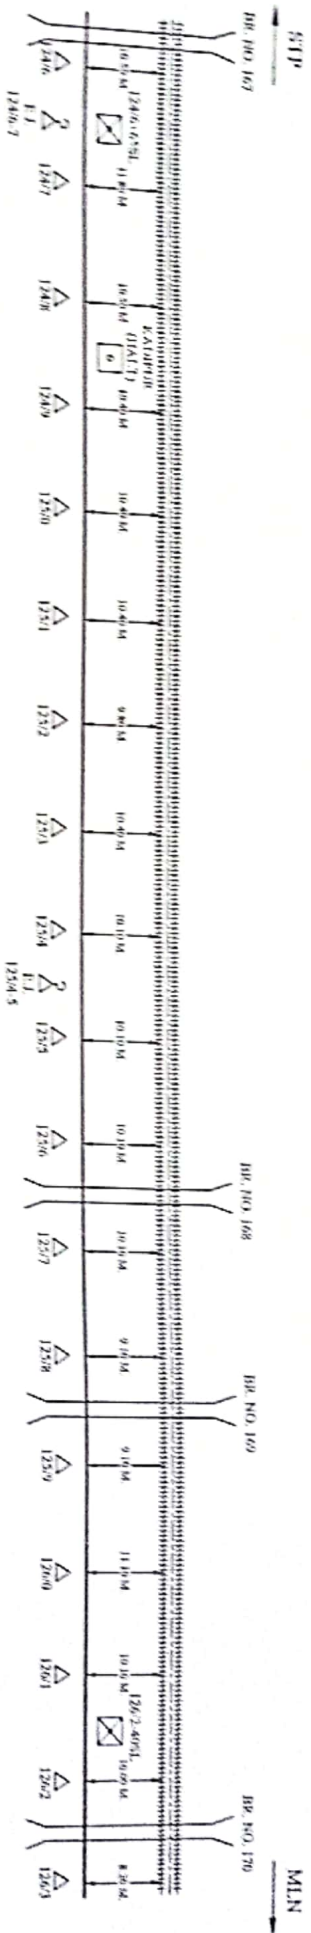

☒	EMERGENCY SOCKET	☐	GATE LODGE	☐	RUB	☐	L.C. PHONE	☐	CREATED ON	☐	CREATED BY	☐	OFFERED BY	☐	APPD. BY	☐	REF: NE/	☐	NOT TO SCALE ALL READING IN MTR.
☒	LEVEL CROSSING GATE	☐	MAJOR BRIDGE	☐	GL PIPE	☐	C/T/P	☐	CABLE THROUGH PIPE	☐	REVISION ON	☐	MODIFIED ON	☐	REF: NE/	☐	NOT TO SCALE ALL READING IN MTR.	☐	NOT TO SCALE ALL READING IN MTR.
☒	OFC JOINT	☐	TRACK	☐	HDP/PIPE	☐	C/U/G	☐	CABLE UNDER GROUND	☐	MODIFIED ON	☐	REF: NE/	☐	NOT TO SCALE ALL READING IN MTR.	☐	NOT TO SCALE ALL READING IN MTR.	☐	NOT TO SCALE ALL READING IN MTR.

CONTRACTOR

SSE/TELE/CON/LIN

DSTE/CON/LIN

DY/STE/CON/LIN



 
N.E. RAILWAY

MR. ASHOK KUMAR SINGH, JAGANNATH PUR, GORAKHPUR

SITAPUR JN - MAILANI JN

6 QUAD & O.F.C. CABLE ROUTE PLAN (SITAPUR JN. - MAILANI JN.)

HA-LMP

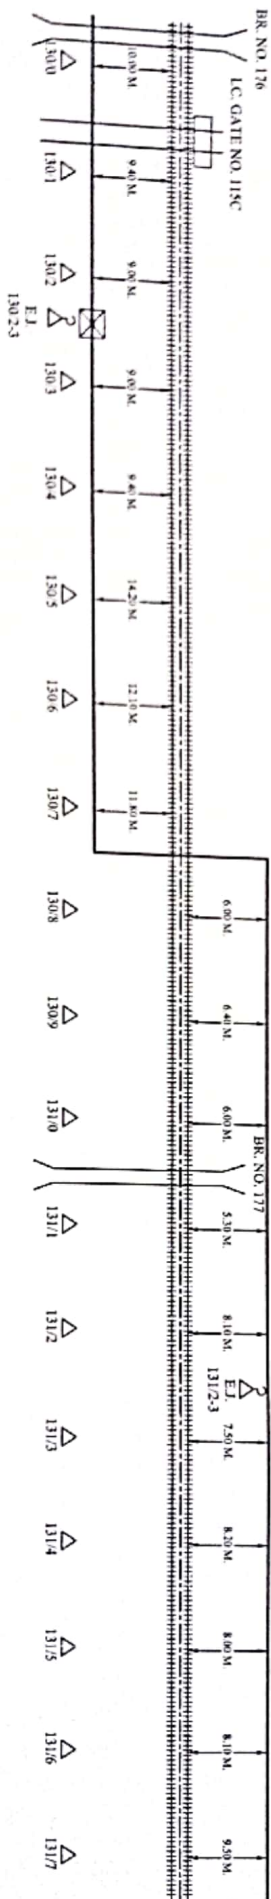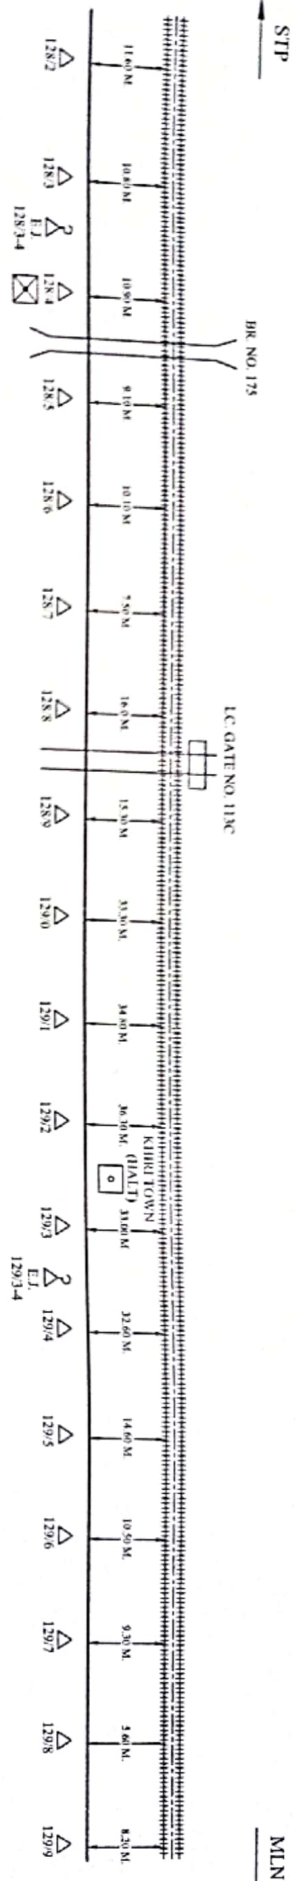

CONTRACTOR
H.P. Singh


SSE/TELE CON/LIN
S. Singh

DSTE/CON/LIN
S. Singh

DY/STE/CON/LIN
S. Singh

Δ	EMERGENCY SOCKET	GATE LODGE	RUB	L.C. PHONE	CUSTOMER NAME: N.E. RAILWAY			
+	LEVEL CROSSING GATE	MAJOR BRIDGE	GL PIPE	C/T/P	PREPARED BY:	M. ASHOK KUMAR SINGH, JAGANNATH PUR, GORAKHPUR		
⊗	OFC JOINT	TRACK	HDPE PIPE	C/U/G	SHEET NO:	12	CREATED BY:	
					MODIFIED ON:		OFFERED BY:	
							APPD. BY:	
							REF:- NE/	
								LOCATION:- SITAPUR JN. - MAILANI JN.
								NOT TO SCALE ALL READING IN MTR.

6 QUAD & O.F.C. CABLE ROUTE PLAN (SITAPUR JN. - MAILANI JN.)

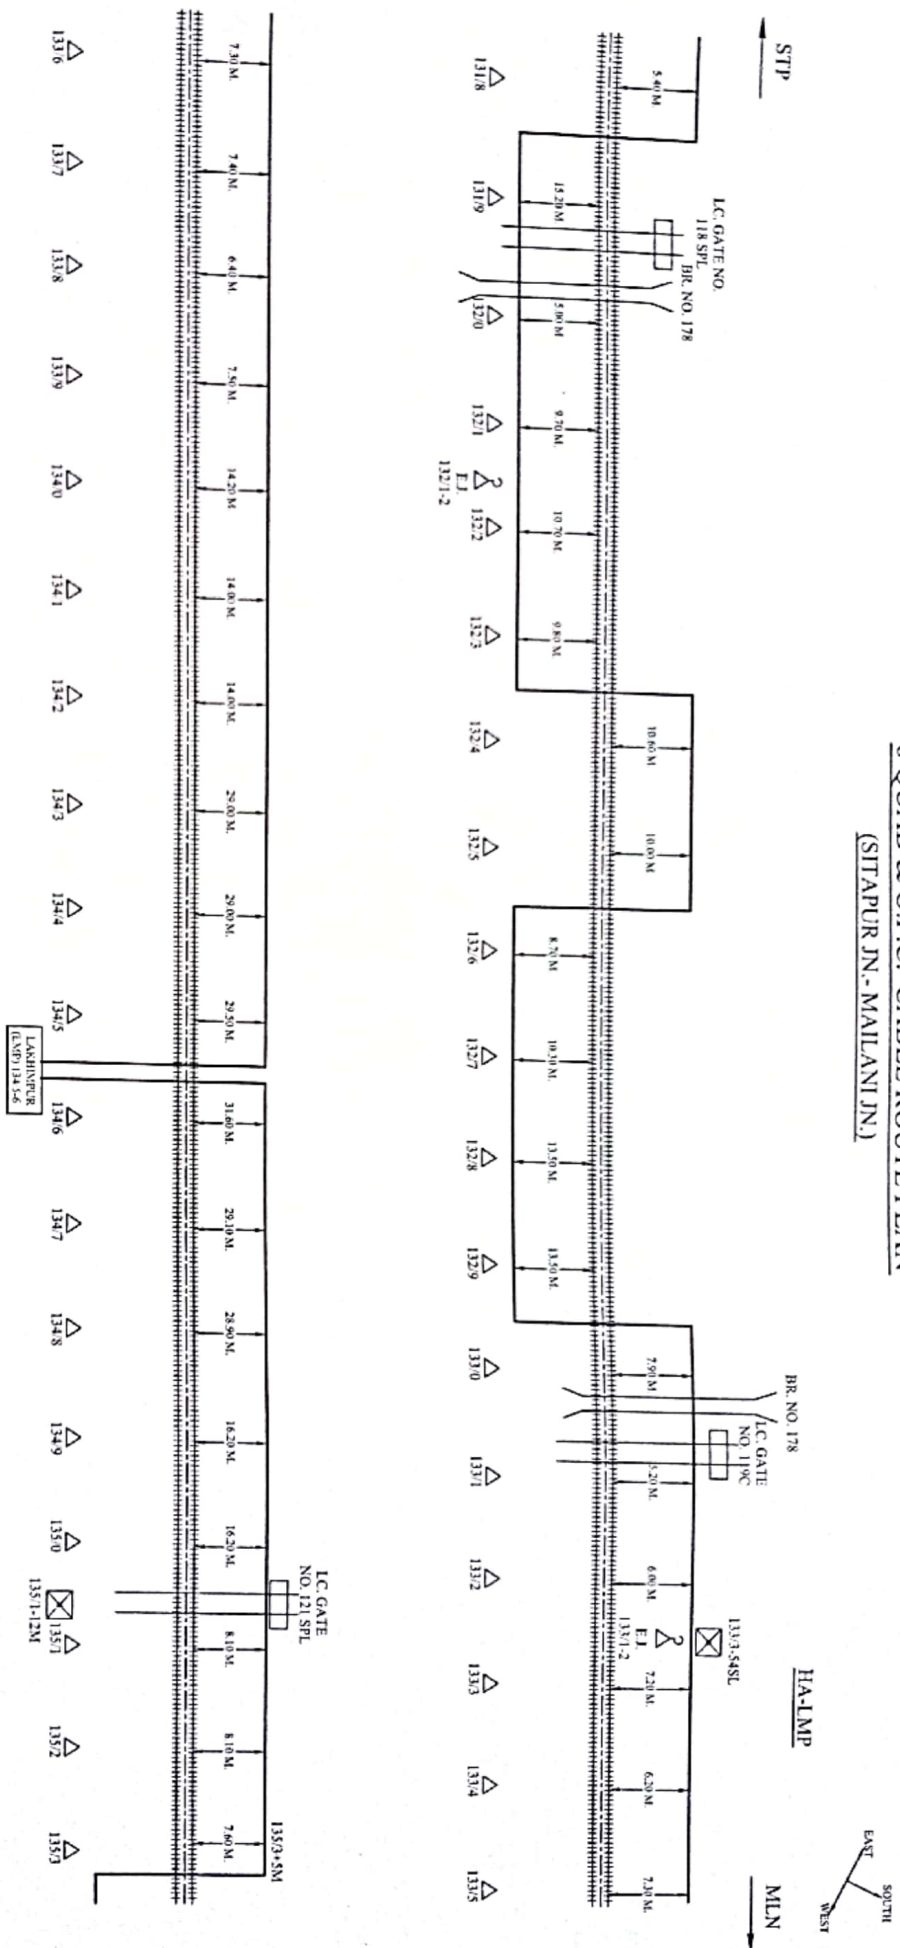

CONTRACTOR

SSE/TELE/CON/LIN

DSTE/CON/LIN

DY/CTE/CON/LIN

CUSTOMER NAME:		N.E. RAILWAY	
PREPARED BY:		MRS. ASHOK KUMAR SINGH, JAGADNATH PUR, GORAKHPUR	
SHEET NO.		13	
CREATED ON		OFFERED BY	
REVISION ON		APPD. BY	
MODIFIED ON		REF. NO.	

SITAPUR JN. - MAILANI JN.

☒	EMERGENCY SOCKET	☐	GATE LODGE	☐	RUB	☐	L.C. PHONE	☐	CREATED ON	☐	OFFERED BY	☐	APPD. BY	☐	REF. NO.	NOT TO SCALE ALL READING IN MTR.
☐	LEVEL CROSSING GATE	☐	MAJOR BRIDGE	☐	G.I. PIPE	☐	CT/P	☐	CABLE THROUGH PIPE	☐	MODIFIED ON	☐	REF. NO.	☐	NOT TO SCALE ALL READING IN MTR.	
☐	OFC JOINT	☐	TRACK	☐	HDPE PIPE	☐	C/V/G	☐	CABLE UNDER GROUND	☐	MODIFIED ON	☐	REF. NO.	☐	NOT TO SCALE ALL READING IN MTR.	

(STAPUR JN.-MALANI JN.)

CONTRACTAR

 
DSTE/CON/LJN

DY/CSTE/CON/LN

N.E. RAILWAY

SITAPUR JN.-MALLANI JN



6 QUAD & O.F.C. CABLE ROUTE PLAN (SITAPUR JN.- MAILANI JN.)



LMP-PD

STP

MLN

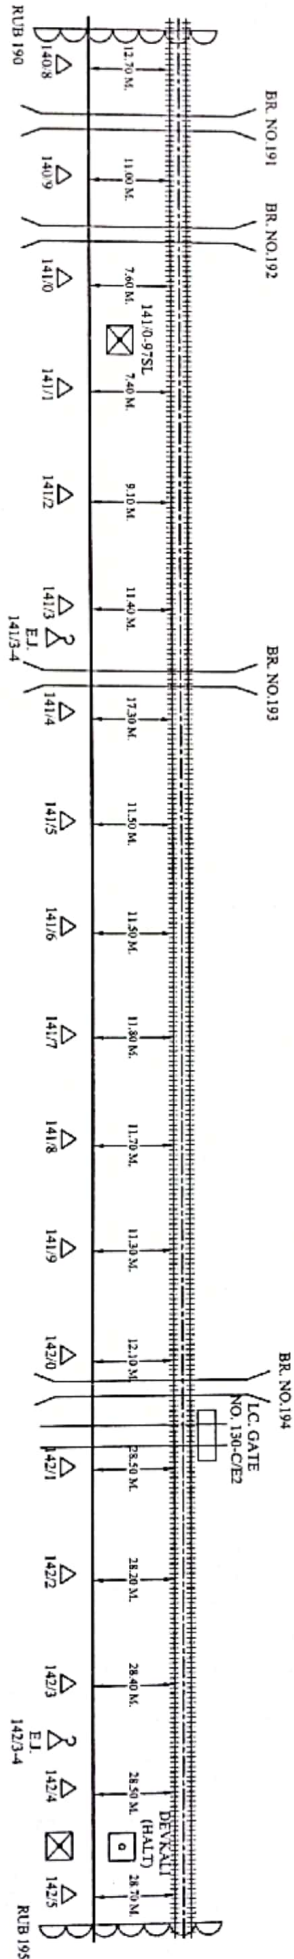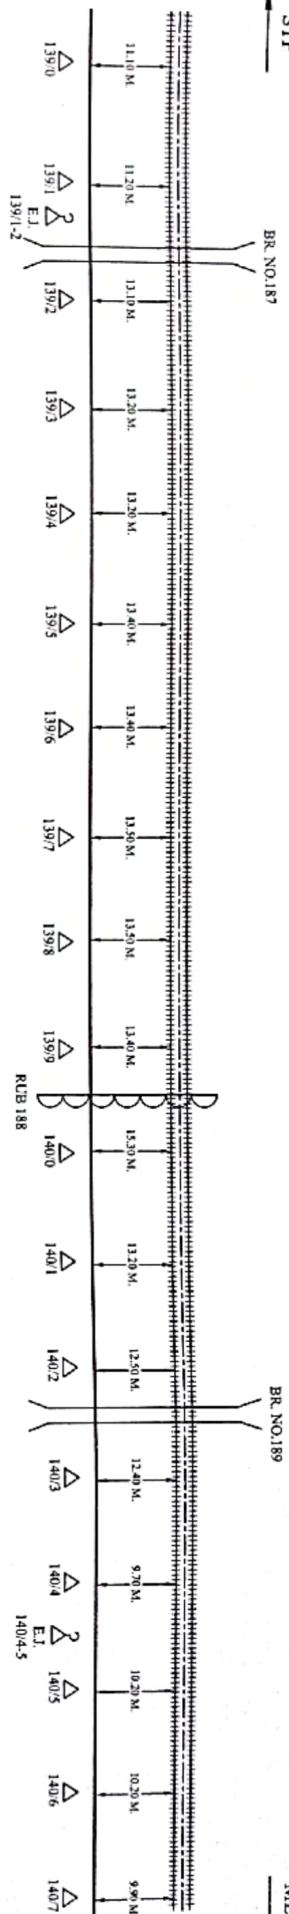

CONTRACTOR

SSE/TELE/CON/LIN

DSTE/CON/LIN



DY/CSTE/CON/LIN

☒	EMERGENCY SOCKET	☐	GATE LODGE	☐	RUB	☐	L.C. PHONE
☒	LEVEL CROSSING GATE	☐	MAJOR BRIDGE	☐	GL PIPE	☐	C/T/P
☒	OFC JOINT	☐	TRACK	☐	HDPE PIPE	☐	C/U/G
☒		☐		☐		☐	

CUSTOMER NAME:		N.E. RAILWAY	
PREPARED BY:	M/S. ASHOK KUMAR SINGH, JAGARNATH PUR, GORAKHPUR	SHEET NO:	15
CREATED ON:		OFFERED BY:	
REVISION ON:		APPD. BY:	
MODIFIED ON:		REF. NE/	
LOCATION:- SITAPUR JN.- MAILANI JN.			
NOT TO SCALE ALL READING IN MTR.			

6 QUAD & O.F.C. CABLE ROUTE PLAN (SITAPUR JN.- MAILANI JN.)

LMP-PD

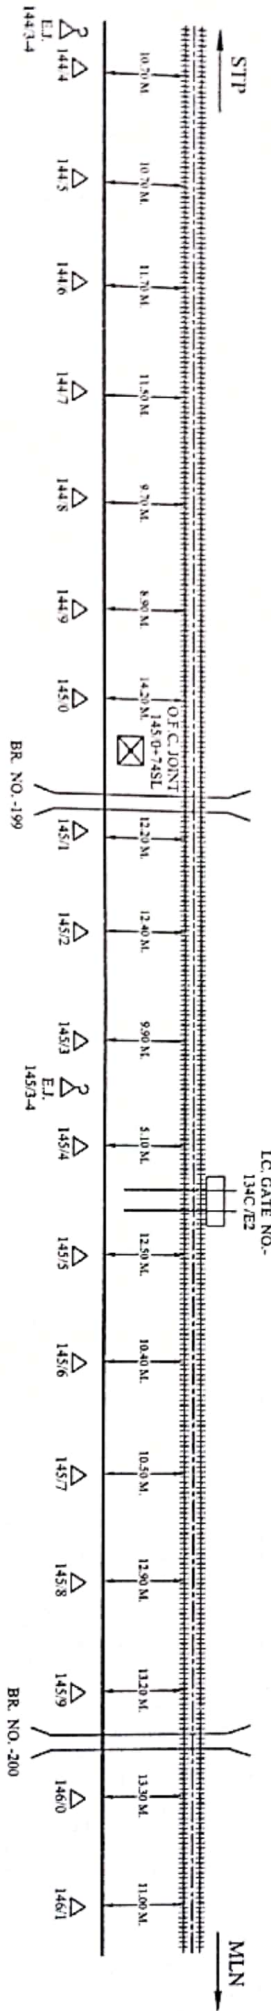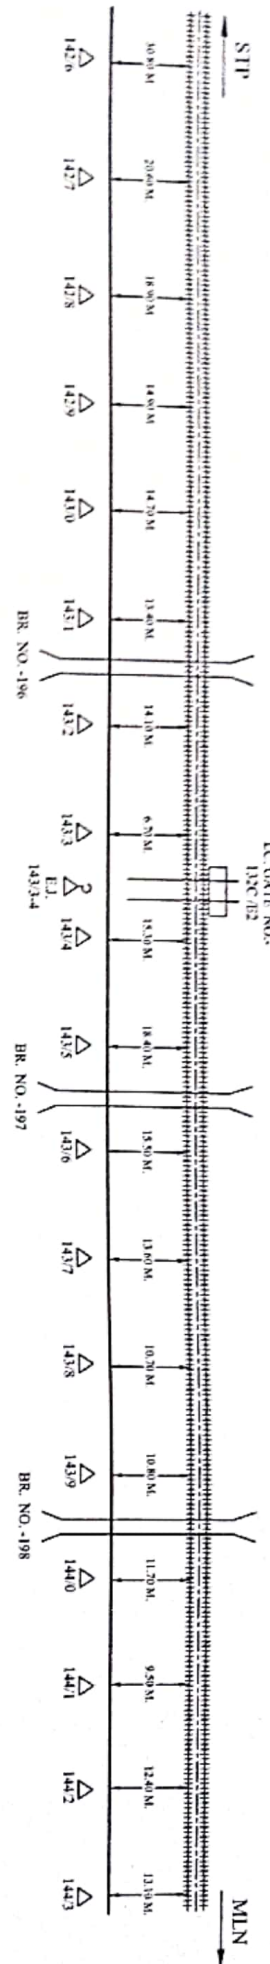

CONTRACTOR

SSE/TELE/CON/LIN

DSE/CON/LIN



DY/CSE/CON/LIN

EMERGENCY SOCKET	GATE LODGE	RUB	L.C. PHONE	N.E. RAILWAY			
LEVEL CROSSING GATE	MAJOR BRIDGE	G.I. PIPE	CABLE THROUGH PIPE	SITAPUR JN.- MAILANI JN.			
OFC JOINT	TRACK	HDPE PIPE	CABLE UNDER GROUND	NOT TO SCALE ALL READING IN MTR.			

CUSTOMER NAME:	N.E. RAILWAY						
PREPARED BY:	M/S. ASHOK KUMAR SINGH, JAGANNATH PUR, GORAKHPUR						
SHEET NO.	16	CREATED BY		OFFERED BY		APPD. BY	
REVISION ON							
MODIFIED ON							
REF.- NE/							

6 QUAD & O.F.C. CABLE ROUTE PLAN (SITAPUR JN.-MALLANI JN.)

LMP-PD

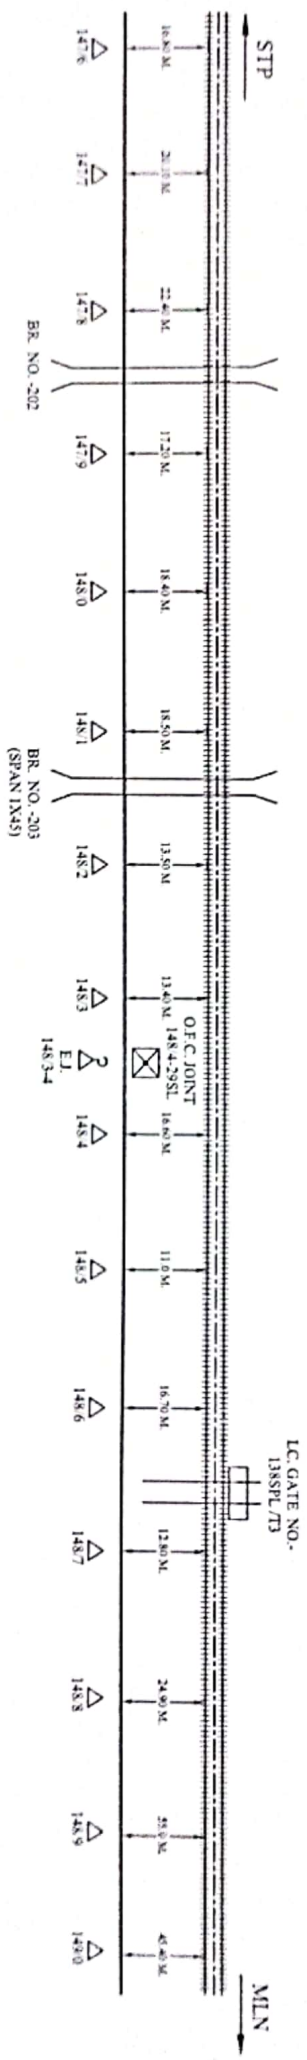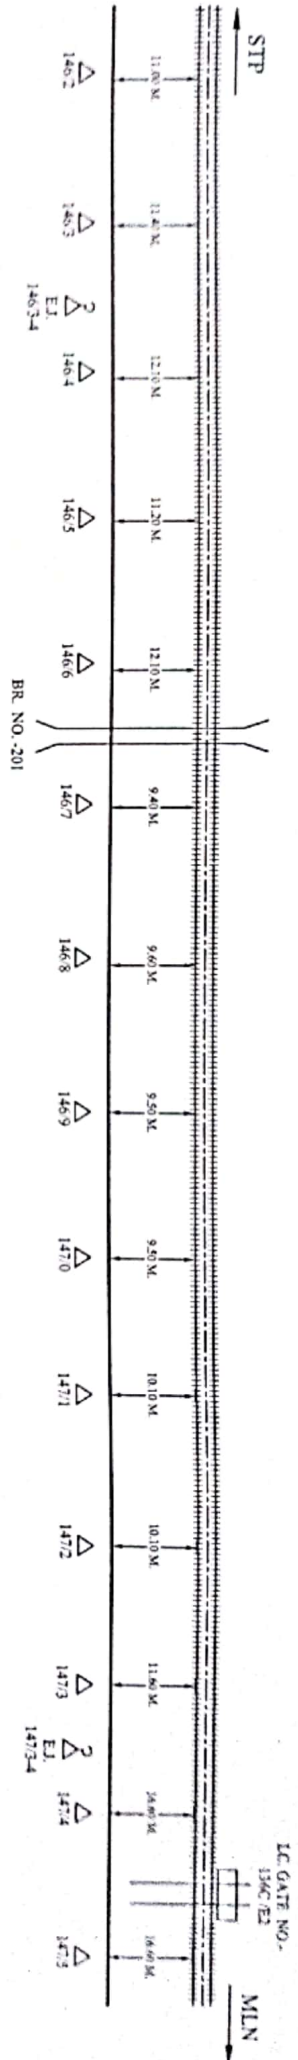

CONTRACTOR

SSE/TELECON/LN

DSE/CON/LN

DY/CTE/CON/LN

☒	EMERGENCY SOCKET	☐	GATE LODGE	☐	RUB	☐	L.C. PHONE	☐	CREATED BY	☐	OFFERED BY	☐	APTD BY	☐	REF. NE	NOT TO SCALE ALL READING IN MTR.
☒	LEVEL CROSSING GATE	☐	MAJOR BRIDGE	☐	G.I. PIPE	☐	C/T/P	☐	CABLE THROUGH PIPE	☐	RIVISION ON	☐	MODIFIED ON	☐	REF. NE	
☒	OFC JOINT	☐	TRACK	☐	HIDPE PIPE	☐	C/U/G	☐	CABLE UNDER GROUND	☐	MODIFIED ON	☐	REF. NE	☐	REF. NE	

CUSTOMER NAME: N.E. RAILWAY

 
PREPARED BY: M.S. ASHOK N. M. SINGH, JAGADYATH P. R. GORAKHPUR

SHEET NO. 17

CREATED ON

LOCATION: SITAPUR JN.-MALLANI JN.

PD-8K



Hi Prof
CONTACTAR

SSE/TELECON/UN

DSTE/CON/LIN

DY/CSTE/CON/LIN

CUSTOMER NAME:	N.E. RAILWAY
PREPARED BY:	MR. ASHOK KUMAR SINGH, JAGADNATH PUR, GORAKHPUR





~~2.11.0~~
~~DY/CTE/CON/JN~~

NOT TO SCALE ALL READING IN MTR.

6 QUAD & O.F.C. CABLE ROUTE PLAN (SITAPUR JN. - MAILANI JN.)

PD-GK

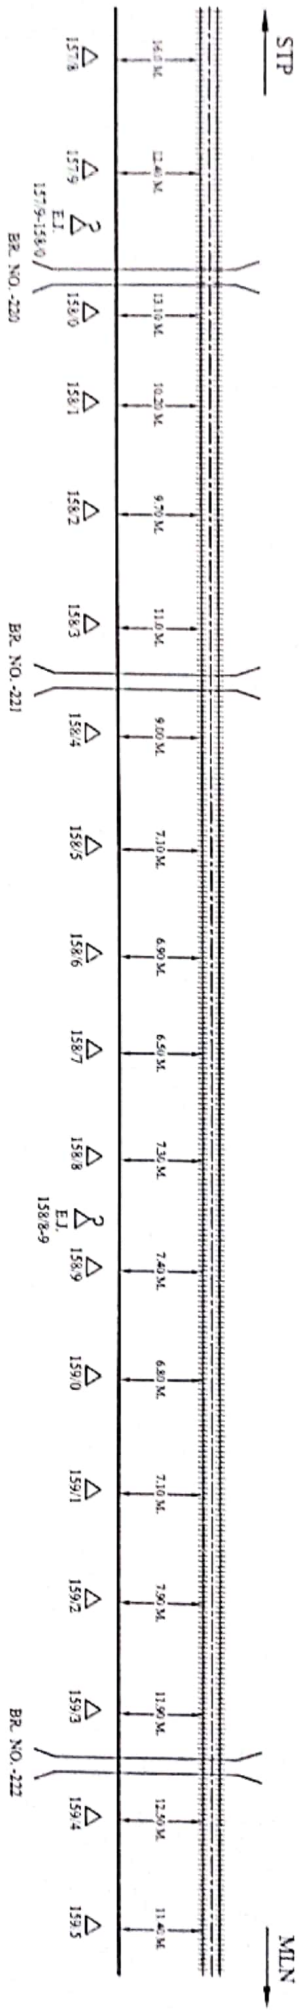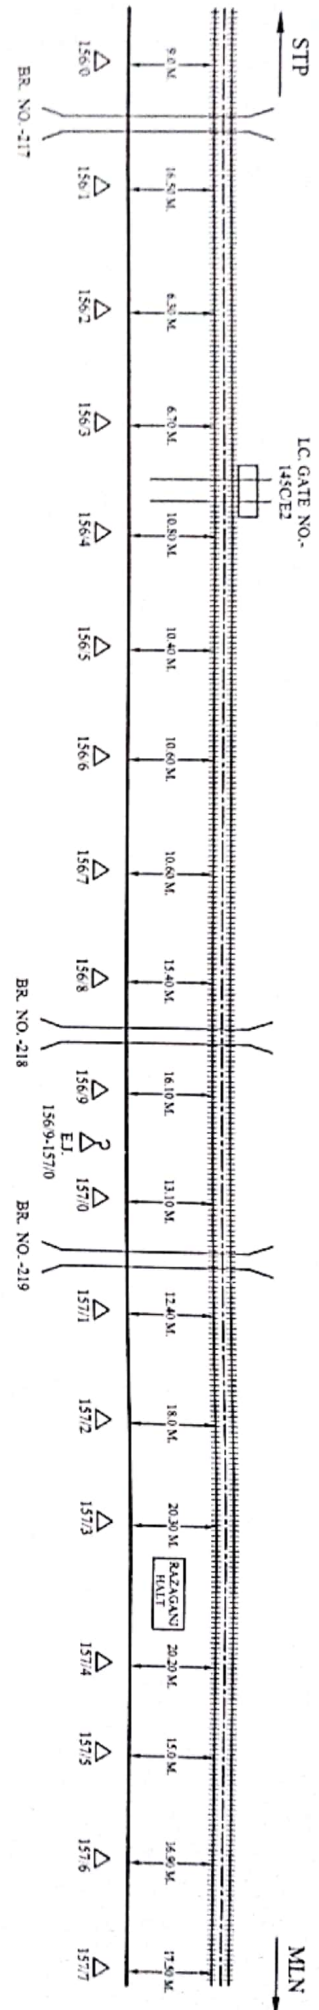

CONTRACTOR		SSE/TELECON/LIN		DYE/TELECON/LIN		DYEST/TELECON/LIN	
2	EMERGENCY SOCKET		GATE LODGE		RUB		L.C. PHONE
1	LEVEL CROSSING GATE		MAJOR BRIDGE		G.I. PIPE		CABLE THROUGH PIPE
2	O.F.C. JOINT		TRACK		HIDE PIPE		CABLE UNDER GROUND


CUSTOMER NAME:		N.E. RAILWAY	
PREPARED BY:	M/A. ASHOK KUNAR SINGH, JAGANNATH PUR, GORAKHPUR		
SHEET NO.	20	CREATED BY	
REVISION ON		OFFERED BY	
MODIFIED ON		APPD. BY	
REF. NO.		NOT TO SCALE ALL READING IN MTR.	

(STAPLE IN MAILING)





CONTRACTAR

 6 QUAD & O.F.C. CABLE ROUTE PLAN (SITAPUR JN. - MAILANI JN.)



PD-GK

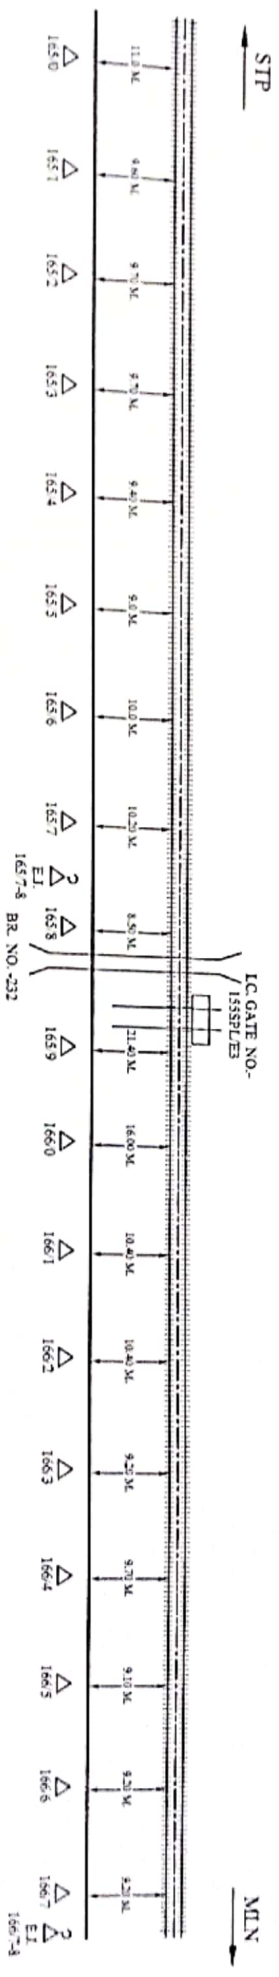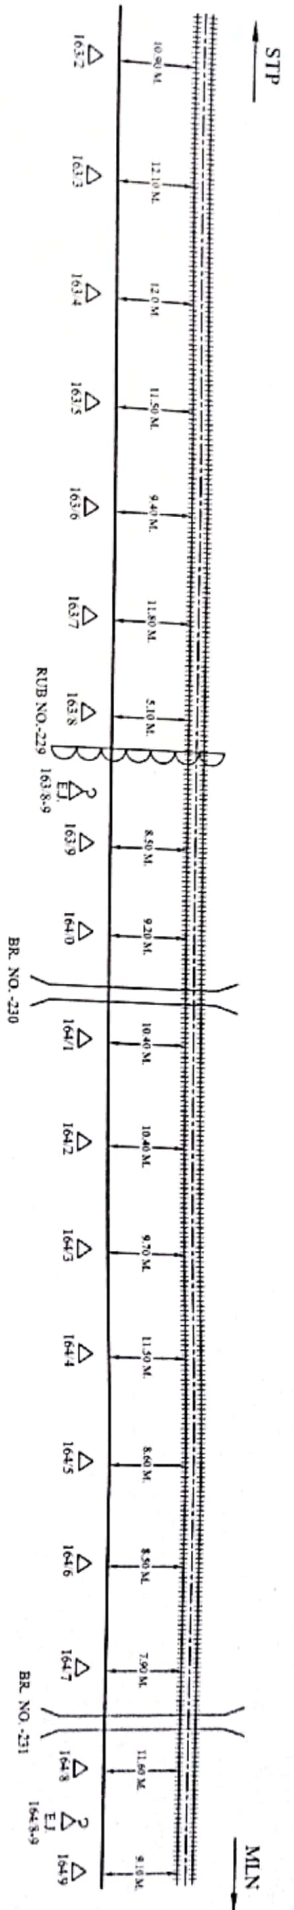

CONTRACTOR



SSE TELECONLIN

DSTE CONLIN

DYASTE CONLIN

CUSTOMER NAME		N.E. RAILWAY	
PREPARED BY:		M.S. ASHOK KUMAR SINGH, JAGANNATH PUL, GORAKHPUR	
SHEET NO.		22	
CREATED ON		CREATED BY	
REVISION ON		OFFERED BY	
APPROD. BY		APPROD. BY	
MODIFIED ON		REF. NE	
NOT TO SCALE ALL READINGS IN MET.		LOCATION: SITAPUR JN. - MAILANI JN.	

6 QUAD & O.F.C. CABLE ROUTE PLAN (SITAPUR JN.- MAILANI JN.)

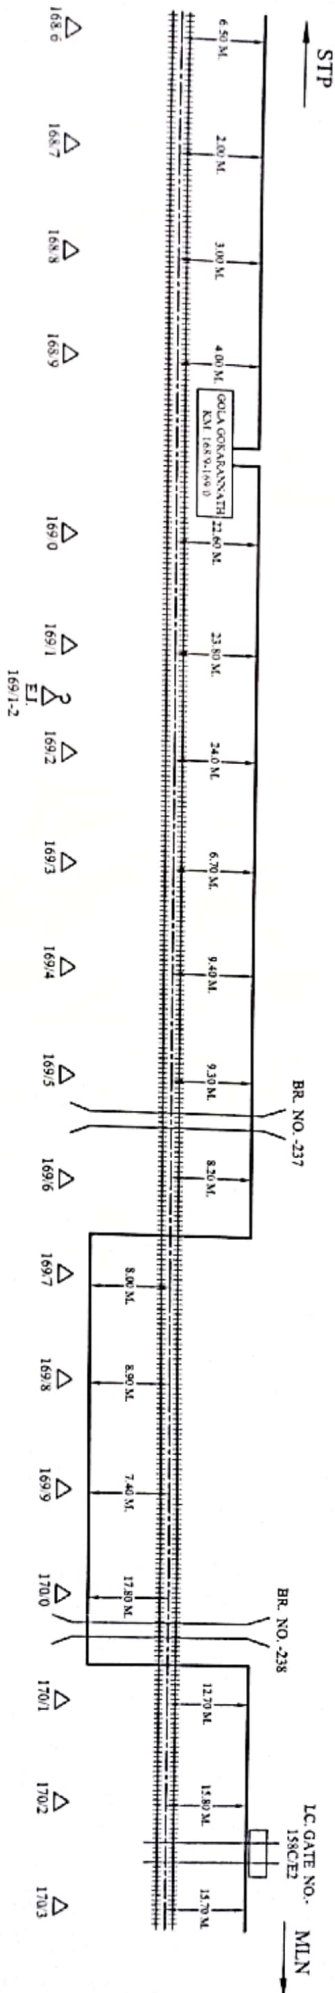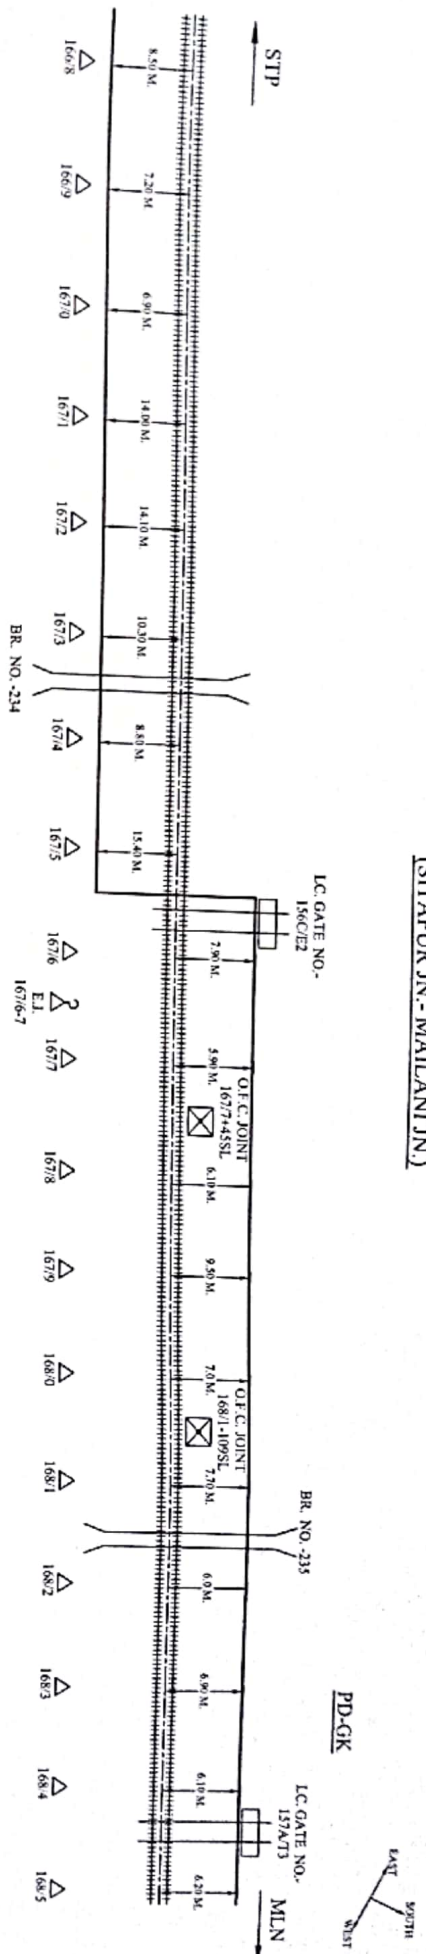

CONTRACTOR

SSE TELECON/LN


DSTE/CON/LN

DY/STE/CON/LN

2	EMERGENCY SOCKET	GATE LODGE	RUB	LC PHONE	CUSTOMER NAME	N.E. RAILWAY			
LEVEL CROSSING GATE	MAJOR BRIDGE	GL PIPE	CT/P	CABLE THROUGH PIPE	PREPARED BY:	M.S. ASHOK KUMAR SINGH, JAGARNAATH PUR, GORAKHPUR			
OFC JOINT	TRACK	HIDE PIPE	CU/G	CABLE UNDER GROUND	SHEET NO	23	CREATED BY	LOCATION:-	SITAPUR JN.- MAILANI JN.
					CREATED ON		OFFERED BY		
					DIVISION ON		APPD. BY		
					MODIFIED ON		REF. NO.		NOT TO SCALE ALL READINGS IN MTR.

601 AD & OF C. CABLE ROUTE PLAN (SITAPUR IN, MAILANI IN)

(SITAPUR IN, MAILANI IN)

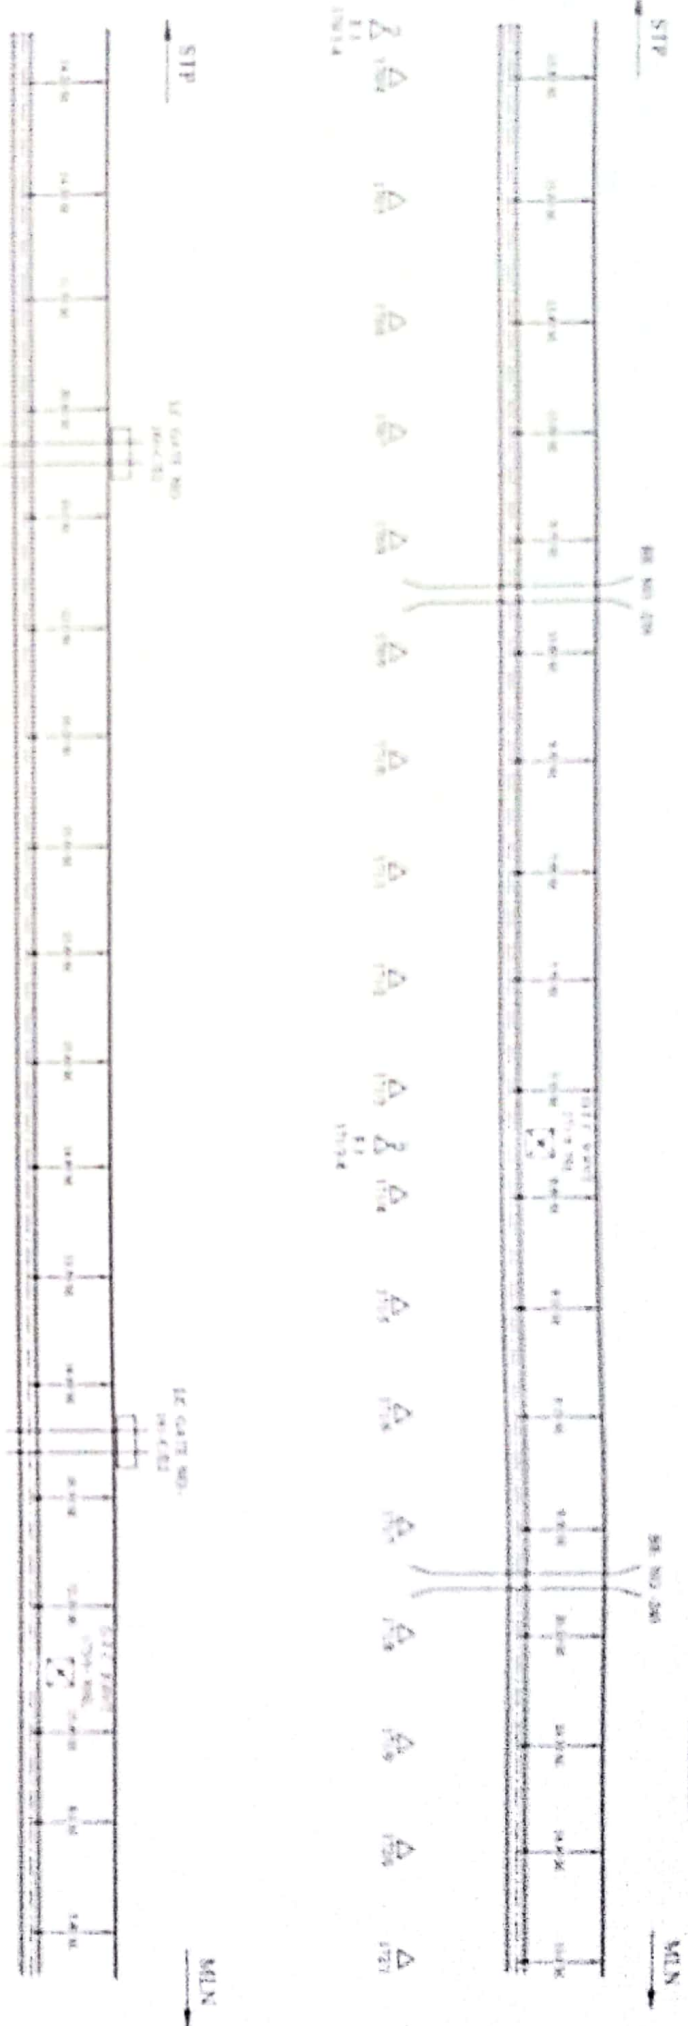

CONTRACTOR

REVISION


DATE

BY

EMERGENCY SIGNAL	GATE LOCK	WIRE	LE. PIERCE
LEVEL CROSSING GATE	MAJOR BARRIER	GL. PIPE	CT. P.
OFF. POINT	TRACK	WIRE PIPE	CL. G.
			CABLE UNDER GROUND

CLIENT'S NAME		N.E. RAILWAY	
PREPARED BY		NO. 10000 BINDER (SITAPUR IN, MAILANI IN)	
SHEET NO.		24	
CREATED BY			
MODIFIED BY			
APPROVED BY			
DATE			
SITAPUR IN, MAILANI IN		NOT TO SCALE ALL DIMENSIONS IN METER	

CHITAPU TH. MAHARAJA

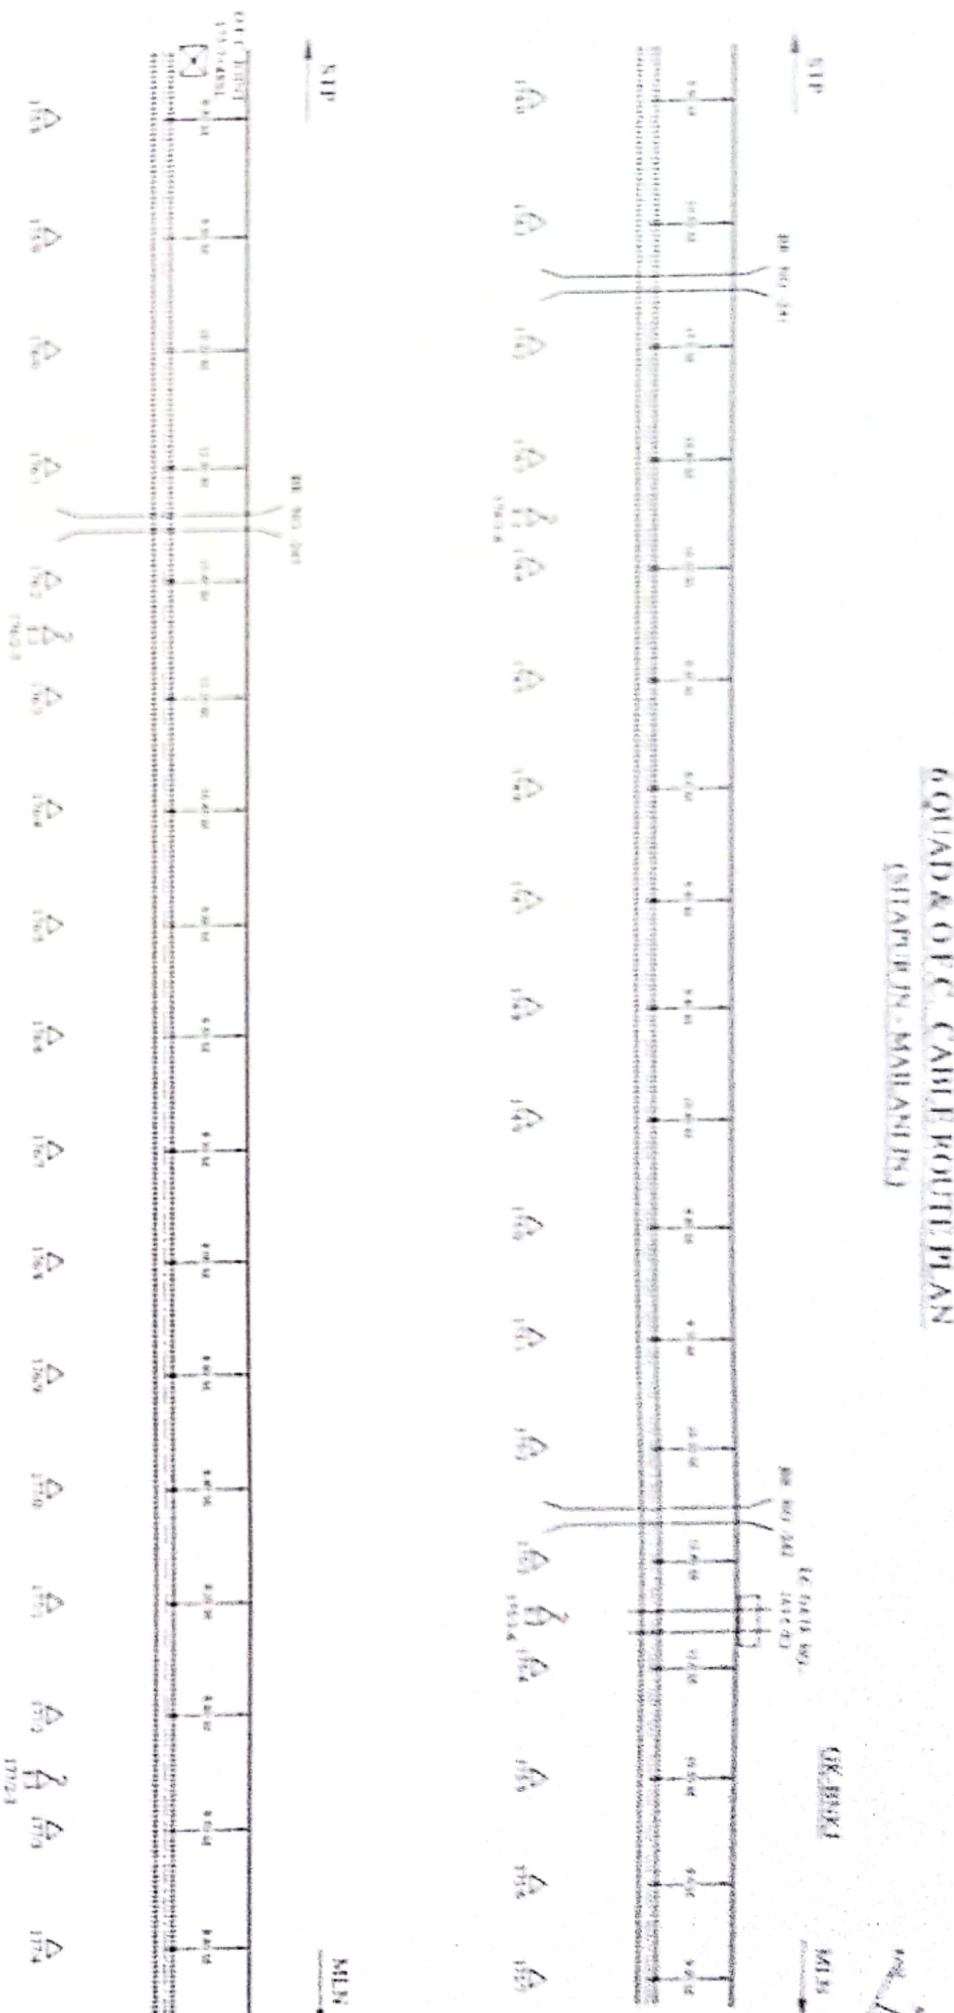

CONTRACTOR <i>As per</i> SITE/CON/LIN <i>2005.04/15</i> DIST/CON/LIN DY/CH/CON/LIN		N.E. RAILWAY MA. ASHOK KUMAR SINGH, JOGGA/NAH/PLR, G/MA/CH/PLR	
 EMERGENCY SOCKET	 GATE LOCK	 RUB	 LC PHONE
 LEVEL CROSSING GATE	 MANOR BRIDGE	 GL PIPE	 CABLE THROUGH PIPE
 GFC JOINT	 TRACK	 HDPE PIPE	 CABLE UNDER GROUND
SHEET NO. 25		CREATED BY	LOCATION:- SITAPUR JN.-MALLANJIN
CREATED ON		OFFERED BY	
REVISION ON		APPD BY	
RECEIVED ON		REP. NO.	NOT TO SCALE ALL PLANNING IN MTR.

 
(SITAPUR JN.- MAILANI JN.)

GK-BNK.I



BR. NO.-245

MILN



AD JUD
CONTRACTAR

SSE/TELE/CON/LJN

DSTE/CON/LJN

DY/CSTE/CON/LJN

CUSTOMER NAME:	N.E. RAILWAY
PREPARED BY:	MR. ASHOK KUMAR SINGH, JAGANNATH PUR, GORAKHPUR

SITAPUR JN.-MAILANI JN.


6 QUAD & O.F.C. CABLE ROUTE PLAN (SITAPUR JN. - MAILANI JN.)

BKJ-MLN




STP

BR. NO 111

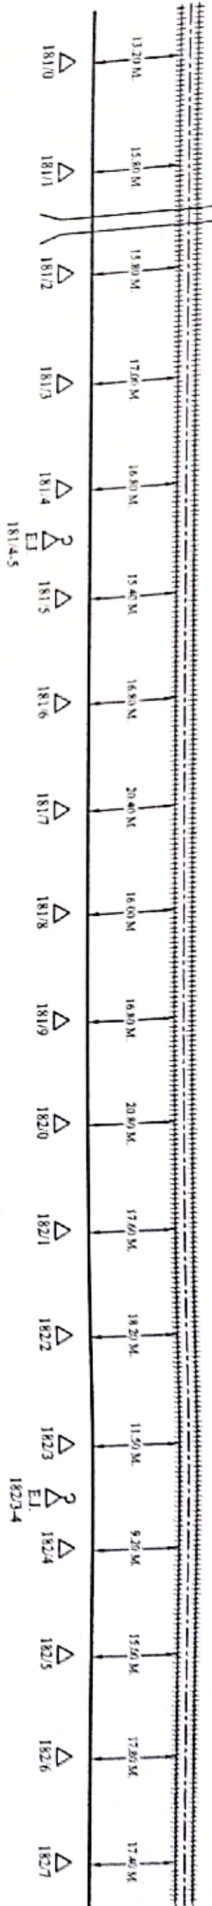

EJ
1813.4

EJ
1844.5

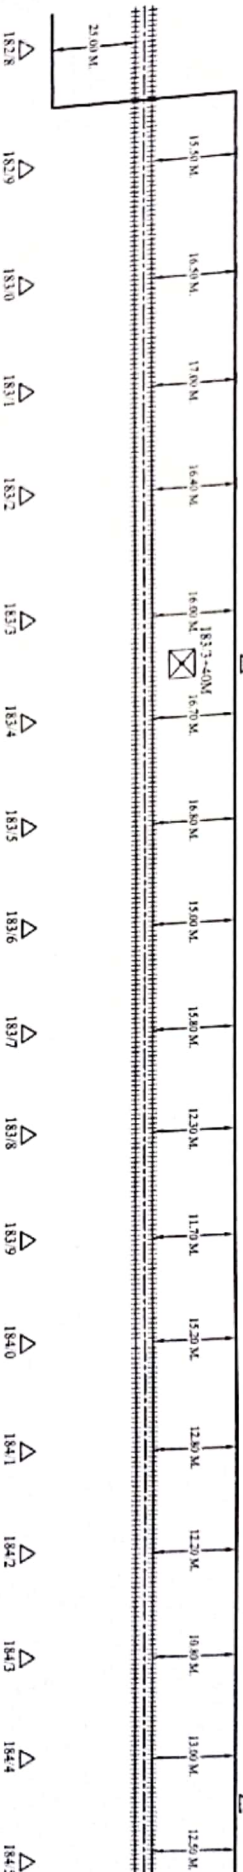

CONTRACTOR

SSE TELECON LN

DSTE CON LN

DY/STE/CON/LN

N.E. RAILWAY


CUSTOMER NAME:	N.E. RAILWAY		
PREPARED BY:	M.S. ASHOK KUMAR SINGH, JAGANNATH PUR, GORAKHPUR		
SHEET NO	27	CREATED BY	
CREATED ON		OFFERED BY	
REVISION ON		APPD. BY	
MODIFIED ON		REF.: NE/	

LOCATION:-

SITAPUR JN. - MAILANI JN.

Δ	EMERGENCY SOCKET	□	GATE LODGE	⌒	RTB	Σ	L.C. PHONE	NOT TO SCALE ALL READING IN MTR.	
⊞	LEVEL CROSSING GATE	⊞	MAJOR BRIDGE	□	G.I. PIPE	CTP	CABLE THROUGH PIPE		
⊞	OFF JOINT	⊞	TRACK	□	HDPE PIPE	C/U/G	CABLE UNDER GROUND		
⊞		⊞		⊞					

6 QUAD & O.F.C. CABLE ROUTE PLAN (SITAPUR JN. - MAILANI JN.)

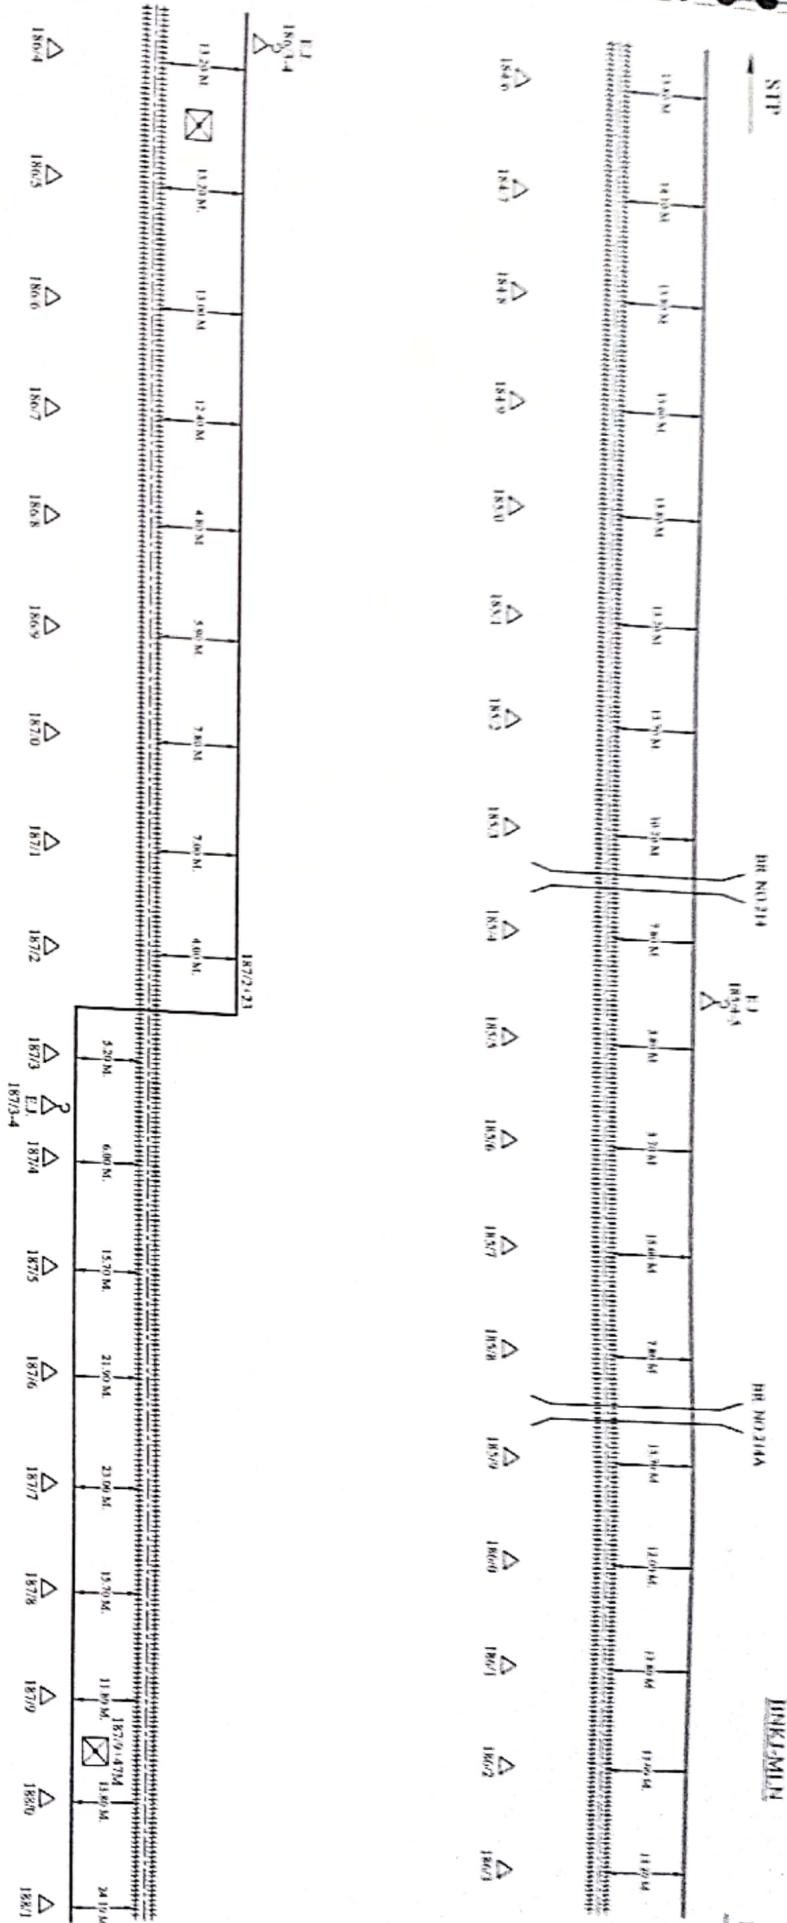

CONTRACTOR
Handwritten signature

SSE/TELECON/LIN
Handwritten signature


DY/STE/CON/LIN
Handwritten signature

2	EMERGENCY SOCKET		GATE LODGE		RUB		L.C. PHONE	CREATED ON	CREATED BY	LOCATION:-
	LEVEL CROSSING GATE		MAJOR BRIDGE		GL PIPE		C/TIP	REVISION ON	OFFERED BY	SITAPUR JN. - MAILANI JN.
	OFC JOINT		TRACK		HDP PIPE		C/U/G	MODIFIED ON	REF. NO.	

CUSTOMER NAME:	N.E. RAILWAY
PREPARED BY:	M.S. ASHOK KUMAR SINGH, JAGADNATH PUR, GOPALPUR
SHEET NO.	28
CREATED ON	CREATED BY
REVISION ON	OFFERED BY
MODIFIED ON	APPD. BY
REF. NO.	NOT TO SCALE ALL PLEADING IN MTR.

6 QUAD & O.F.C. CABLE ROUTE PLAN (SITAPUR JN.- MAILANI JN.)



BKJ-MLN

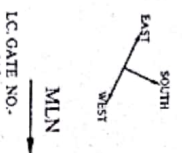

LC GATE NO.-
215

MLN

STP

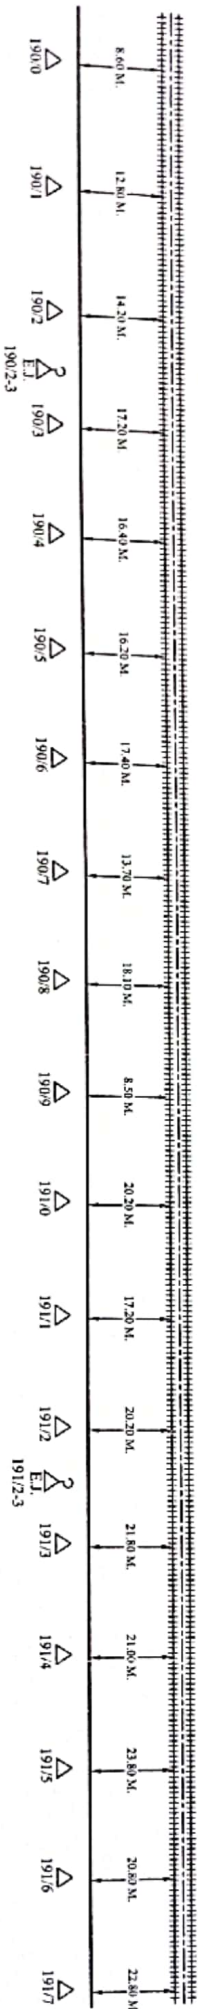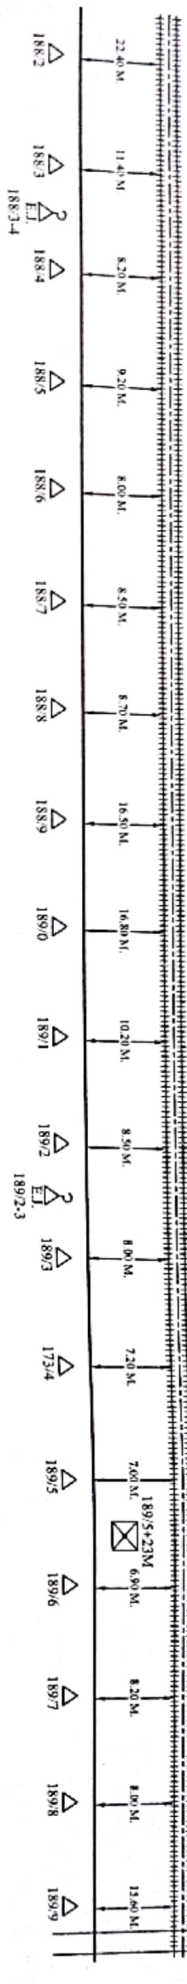

CONTRACTOR

SSE/TELECON/LIN

DSTE/CON/LIN

DY/STE/CON/LIN

CUSTOMER NAME: N.E. RAILWAY
PREPARED BY: M/S. ASHOK KUMAR SINGH, JAGADNATH PUR, GORAKHPUR

SHEET NO. 29

CREATED BY

LOCATION:-

SITAPUR JN.- MAILANI JN.

CREATED ON

OFFERED BY

LOCATION:-

REVISION ON

APPD. BY

LOCATION:-

MODIFIED ON

REF.- NE/

NOT TO SCALE ALL READING IN MTR.

EMERGENCY SOCKET

GATE LODGE

RUB

L.C. PHONE

LEVEL CROSSING GATE

MAJOR BRIDGE

G.I. PIPE

C/T/P

CABLE THROUGH PIPE

RIVISION ON

APPD. BY

LOCATION:-

OFC JOINT

TRACK

HDPE PIPE

C/U/G

CABLE UNDER GROUND

MODIFIED ON

REF.- NE/

LOCATION:-



NOT TO SCALE ALL READING IN MTR.

6 QUAD & O.F.C. CABLE ROUTE PLAN (SITAPUR JN. - MAILANI JN.)

SID

DEKLMN

MLN

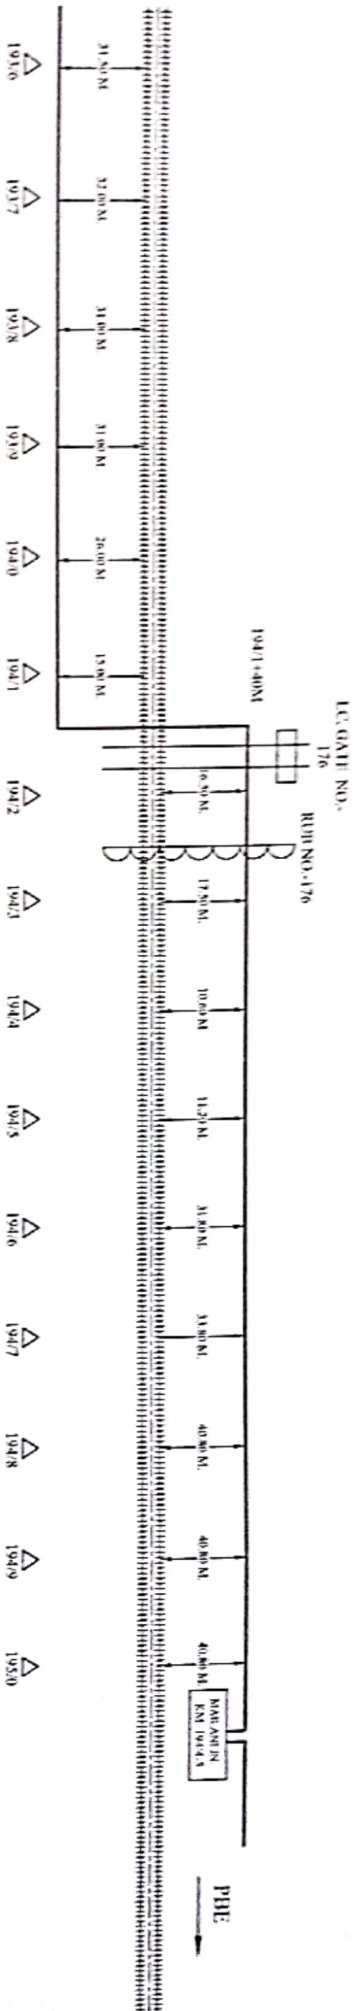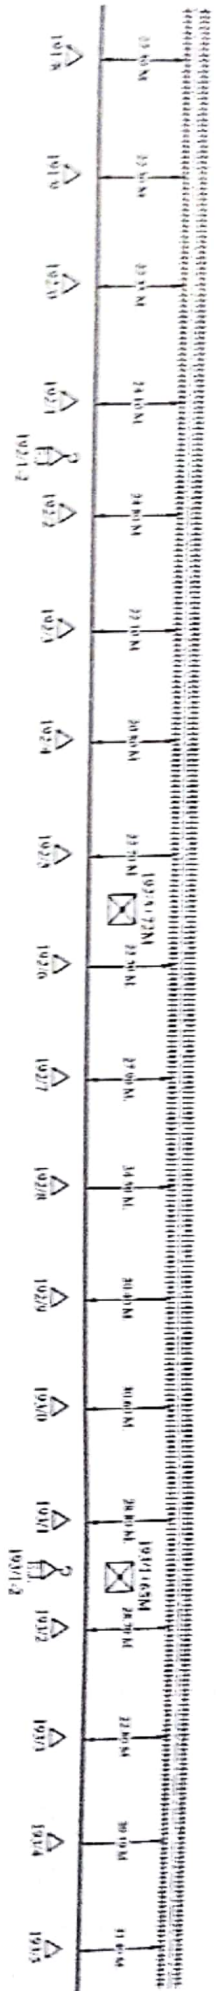

CONTRACTOR

SSI/TELE/CON/LIN

DSTE/CON/LIN

DY/CTTE/CON/LIN

CUSTOMER NAME:		N.E. RAILWAY	
PREPARED BY:		MR. ASHOK KUMAR SINGH, JAGANNATHPUR, GORAKHPUR	
SHEET NO.	30	CREATED BY	
CREATED ON		OFFERED BY	
REVISION ON		APPD. BY	
MODIFIED ON		REF. - NE/	

LOCATION:-

SITAPUR JN. - MAILANI JN

EMERGENCY SOCKET	GATE LODGE	RUB	L.C. PHONE
LEVEL CROSSING GATE	MAJOR BRIDGE	G.I. PIPE	CABLE THROUGH PIPE
OFC JOINT	TRACK	HIDPE PIPE	CABLE UNDER GROUND